

ERV	>			āj.					3			E	NE	RGY	REC	OVE	RY L	INI	rsc	HE	DUL	Ξ (F	PAR	T 2)				-11-			<u> </u>
		ENERGY RECOVERY WHEEL PERFORMANCE WINTER CONDITIONS DESIGN SUMMER CONDITIONS DESIGN				SUPPLY FAN SOUND POWER BY OCTAVE BAND					EXHAUST NORMAL FAN SOUND POWER BY OCTAVE BAND					WEIGHT	SUPPLY	OUTDOOR	EXHAUST	MANUFACTURER	REMARKS										
110	OUT(DOOR WB 'F	DB 'F	OOR RH%	DB 'F	WB 'F	DB 'F	OOR RH%	63 12 Hz H	5 250 Hz	500 1 Hz	000 200 Hz Hz	0 4000 Hz	8000 Hz	A DB	SONE	S 63 Hz	125 250 Hz Hz	0 500 10 Hz Hz	000 200 dz H:	00 4000 Hz	000 Hz	LWA	DBA	SONES	LBS		FILTER	MODEL NUMBER		
4ERV-1	7.4	5.3	46.7				80.7			-	-	- -	-		- 1	-	-	- -		- -	-	-	-	-	-	5,202	-	=	-	GREENHECK RVE-120-74-30H	0234567
4ERV-2	7.4	5.3	46.7	50	90.8	76.2	80.7	50		-	-		-		-	-	-			- -	-	-	-) -	-	3,521		-		GREENHECK RVE-85-58-30H	0234567
																			PE											GREENHECK	
9ERV-2	7.4	5.3	63.5	50	90.8	76.2	80.7	50		-	-	- -	-		_	-	-			_	_	_	-	-	_	2.386	_	-		GREENHECK	0234567

1) BASE RAILS 2 LOW LEAKAGE DAMPERS 3 RECIRC. DAMPER 4) FACTORY SUPPLY & EXHAUST FAN VFD 5 ENERGY BYPASS WHEEL DAMPER 6) FACTORY MOUNTED DISCONNECT 7 SINGLE POINT POWER CONNECTION

EUH	//	ELECTE	RIC L	JNIT	HE	ATER	SCHEDULE	
	//	CAPACITY		FAN I	DATA	777	Turk Carlot	
TAG NO.	BUILDING	KW	СЕМ	v	PH	HZ	MANUFACTURER MODEL NUMBER	REMARKS
EUH-1	FINAL CLARIFIER 1 & 2 PUMP STATION	7.5	270	480	3	60	QMARK QWD07432	=
EUH-2	FINAL CLARIFIER 1 & 2 PUMP STATION	7.5	270	480	3	60	QMARK QWD07432	1
EUH-3	SLUDGE PUMP STATION NO.1	10	270	480	3	60	QMARK QWD10432	= =
EUH-4	SLUDGE PUMP STATION NO.1	10	270	480	3	60	QMARK QWD10432	=
EUH-5	FINAL CLARIFIER 3 & 4 PUMP STATION	7.5	270	480	3	60	QMARK QWD07432	12 2
EUH-6	SLUDGE PUMP STATION NO.2	10	270	480	3	60	QMARK QWD10432	
EUH-7	SLUDGE PUMP STATION NO.2	10	270	480	3	60	QMARK QWD10432	· ·

SAS HO. 1

USE CONSINTENT BUILDING NAMES.

	SMP		F	UEL	OIL	SU	BMEF	RSIB	LE F	PUM	P SCHEDULE	
	7.5050 14. 14					RPM	EL	ECTRICA	AL DATA	4		REMARKS
TAG NO.	BUILDING	SYSTEM SERVED T	TYPE	GPM	(FT.)		MOTOR HP	V	PH	HZ	MANUFACTURER MODEL NUMBER	
7SMP-1	SLUDGE HANDLING	FUEL OIL	SUB.	_	-	-	3/4	480	3	60	RED JACKET ALCOHOL	
7SMP-2	SLUDGE HANDLING	FUEL OIL	SUB.	-	-	-	3/4	480	3	60	RED JACKET ALCOHOL	
9SMP-1	ADMIN BUILDING	FUEL OIL	SUB.	-	-	-	3/4	480	3	60	RED JACKET ALCOHOL	
9SMP-2	ADMIN. BUILDING	FUEL OIL	SUB.	-	_	-	3/4	480	3	60	RED JACKET ALCOHOL	

ADMINISTRATION

70H-4 Caledule? 9HP1-14 Schedule or Speci-7HWP-2 Schedule or SpeciPREPARED BY

BETA

REGISTERED PROFESSIONAL

NOT FOR CONSTRUCTION (CONCEPTUAL)

SUBCONSULTANT



Mechanical/Electrical Enginee 150 Grossman Drive, Suite 309 Braintree, Massachusetts 0218-617 328-9215 web: www.sar.com

PROJECT

Taunton Wastewater Treatment Facility Improvements

Taunton, MA

TITLE

Hvac Schedules

_			
NO.	RE	VISIONS	DATE
DRAWN BY:		RLB	
DES	SIGNED BY:	RHB	
CHECKED BY:		RHB	
ISS	UE DATE:	06/19/2020	
BET	TA JOB NO.:	6050	
sc	ALE .		


NONE


For Review Only


SHEET NO.


H-0.2


VAYYEAR - 2018/18009,00 - TAUNTON WWTF UPGRADESHVAC DEPARTMENTPHASE 2/18009,00 HVAC LEGEND SCHEDULE AND DETAILS-PHASE 2.DWG (6

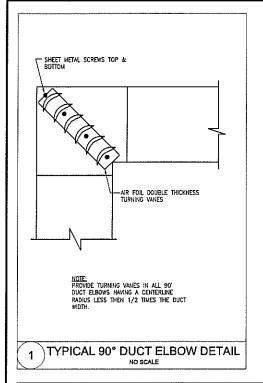


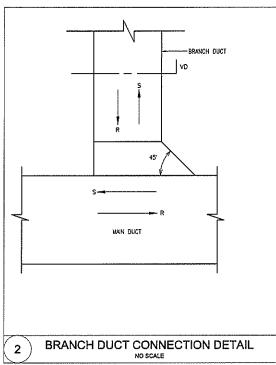


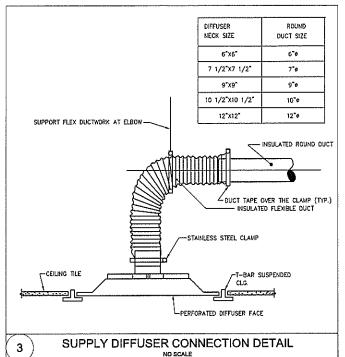


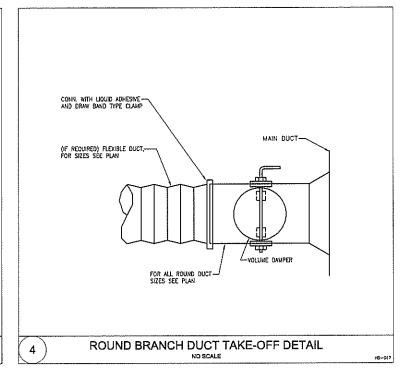

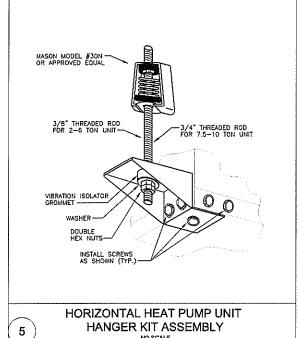

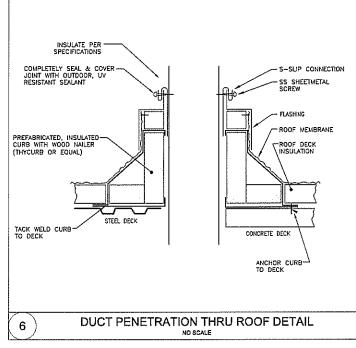

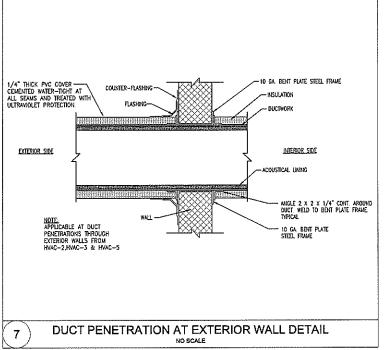

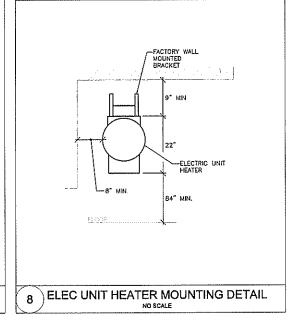



ENGINEERING, INC.

PROJECT

Taunton Wastewater Treatment Facility Improvements

Taunton, MA


TITLE


Hvac Details


DRAWN BY: RLB DESIGNED BY: RHB CHECKED BY: RHB ISSUE DATE: 08/19/2020 BETA JOB NO.: 6050 SCALE

For Review Only SHEET NO.

NONE

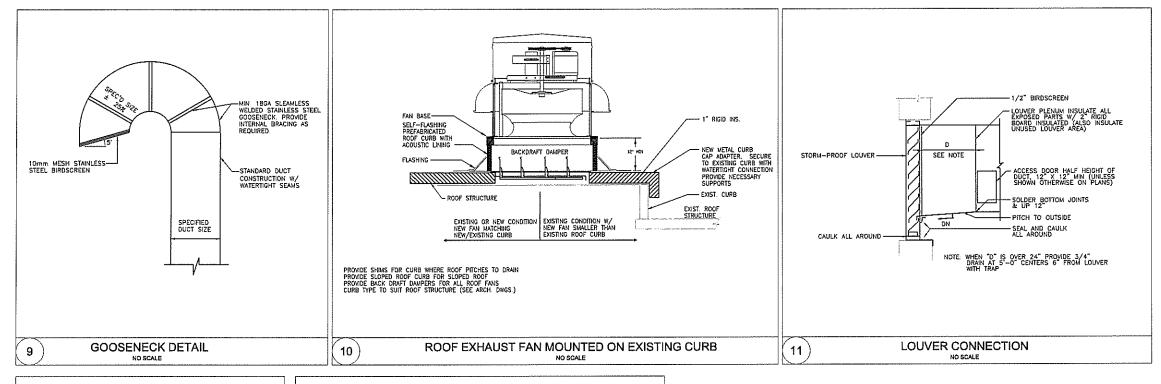

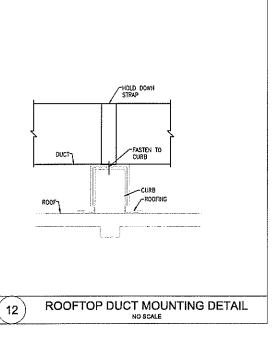

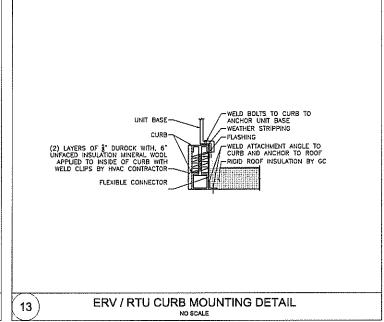

PREPARED BY

BETA-Inc.com

REGISTERED PROFESSIONAL

NOT FOR CONSTRUCTION (CONCEPTUAL)

SUBCONSULTANT



Mechanical/Electrical Enginee: 150 Grossman Drive, Suite 389 Braintree, Massachusetts 0118-617 328-9215

PROJECT

Taunton Wastewater Treatment Facility Improvements

Taunton, MA


TITLE


Hvac Details

_			
			ľ
Ο.		REVISIONS	DATE
OR/	WN BY:	RLB	
Œ	IGNED BY:	RHB	
CHE	CKED BY:	RHB	
SS	JE DATE:	06/19/2020	
ЭЕТ	A JOB NO.:	6050	
SC	ALE		
		NONE	

For Review Only

SHEET NO.

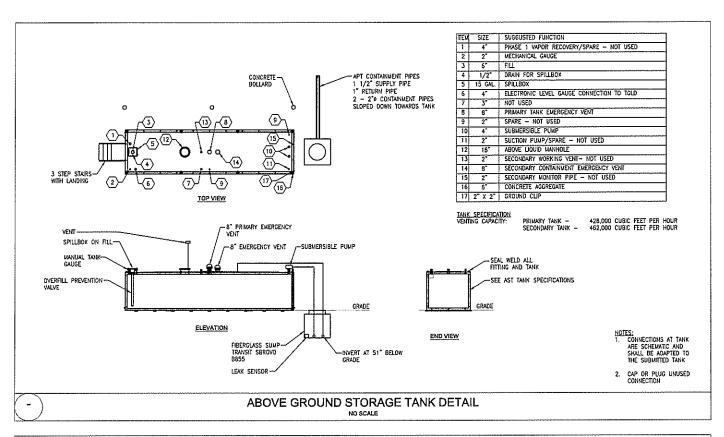

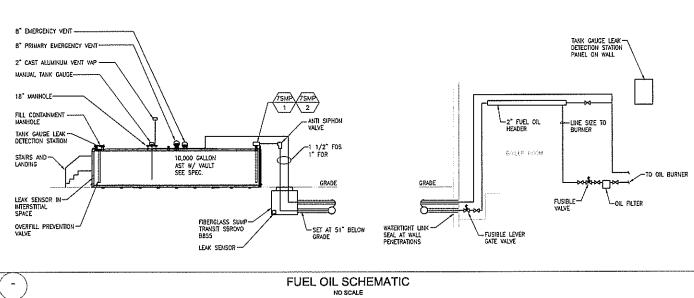

PREPARED BY

BET I

REGISTERED PROFESSIONAL

NOT FOR CONSTRUCTION (CONCEPTUAL)

SUBCONSULTANT



Mechanical/Electrical Engineers 158 Grossman Drive, Sulte 309 Braintree, Massachusetts 02184 517 328-9215 Web: www.ass.com

PROJECT

Taunton Wastewater Treatment Facility Improvements

Taunton, MA

TITLE

Hvac Solid Handling Building Fuel Oil Details


NO.	RE	VISIONS	DAT
DR/	WN BY:	RLB	
DES	IGNED BY:	RHB	
CHE	CKED BY:	RH8	
ıss	UE DATE:	06/19/2020	
BEI	'A JOB NO.:	6050	
sc	ALE		
I			


NONE

For Review Only

H-0.5

SHEET NO.

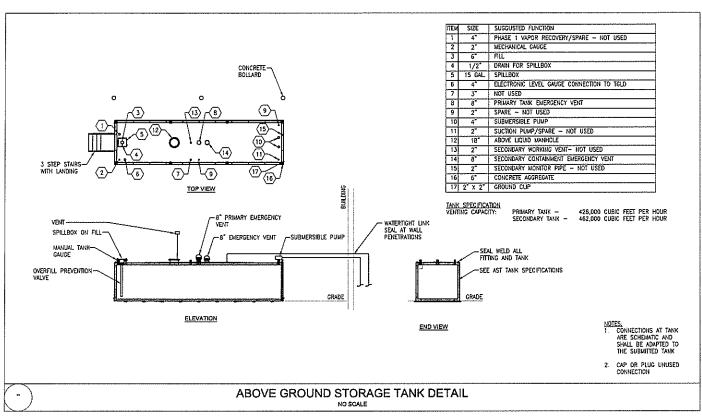

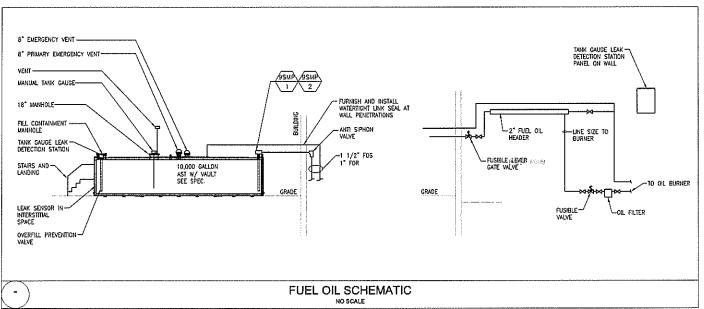

PREPARED BY



REGISTERED PROFESSIONAL

NOT FOR CONSTRUCTION (CONCEPTUAL)

SUBCONSULTANT



Mechanical/Electrical Engineer 150 Grossman Drive, Suite 309 Braintree, Massachusetts 62184 617 318-9215 web: www.ssr.com

PROJECT

Taunton Wastewater Treatment Facility Improvements

Taunton, MA

TITLE

Hvac Admin Building Fuel Oil Details


			-	
			\neg	
Э.	RE	EVISIONS		DATE
R	WN BY:	RLB		
ES	SIGNED BY:	RHB		
H	CKED BY:	RHB		
SS	UE DATE:	08/19/2020		
Ęī	A JOB NO.:	6050	•••••	
_	AI C			


SCALE


NONE


For Review Only

SHEET NO.

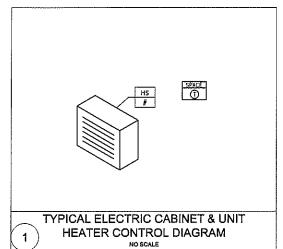


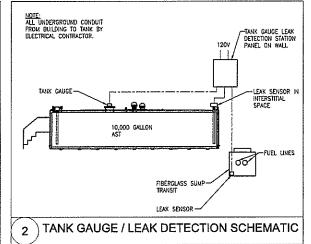

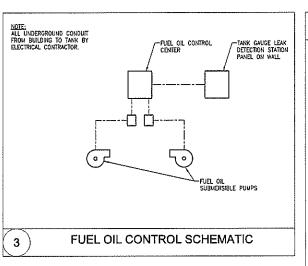

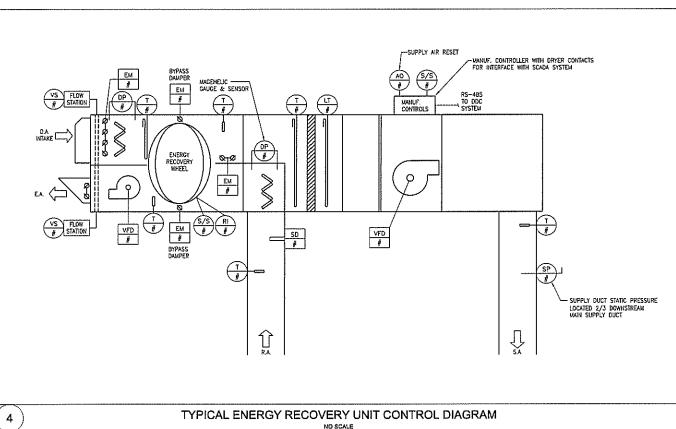



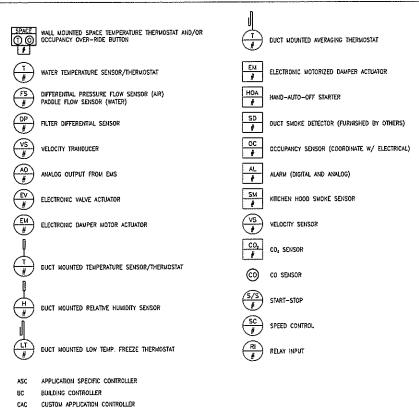

DDCFP DDC FIELD PANEL

CONNECT NEW TO EXISTING

PREPARED BY



REGISTERED PROFESSIONAL

NOT FOR CONSTRUCTION (CONCEPTUAL)

SUBCONSULTANT



Mechanical/Electrical Engineers 158 Grossman Drive, Suite 389 Braintree, Massachusetts 02184 617 328-9215 web: www.sar.com

PROJECT

Taunton Wastewater Treatment Facility Improvements

Taunton, MA

TITLE


Hvac Control Schematics

			1
			<u> </u>
NO.		REVISIONS	DATE
DRA	WN BY:	RLB	
DES	IGNED BY:	RHB	
CHE		D) ID	
	CKED BY:	RHB	
⊢	UE DATE:	06/19/2020	
ISS			
ISS	UE DATE:	06/19/2020	

For Review Only

NONE

SHEET NO.

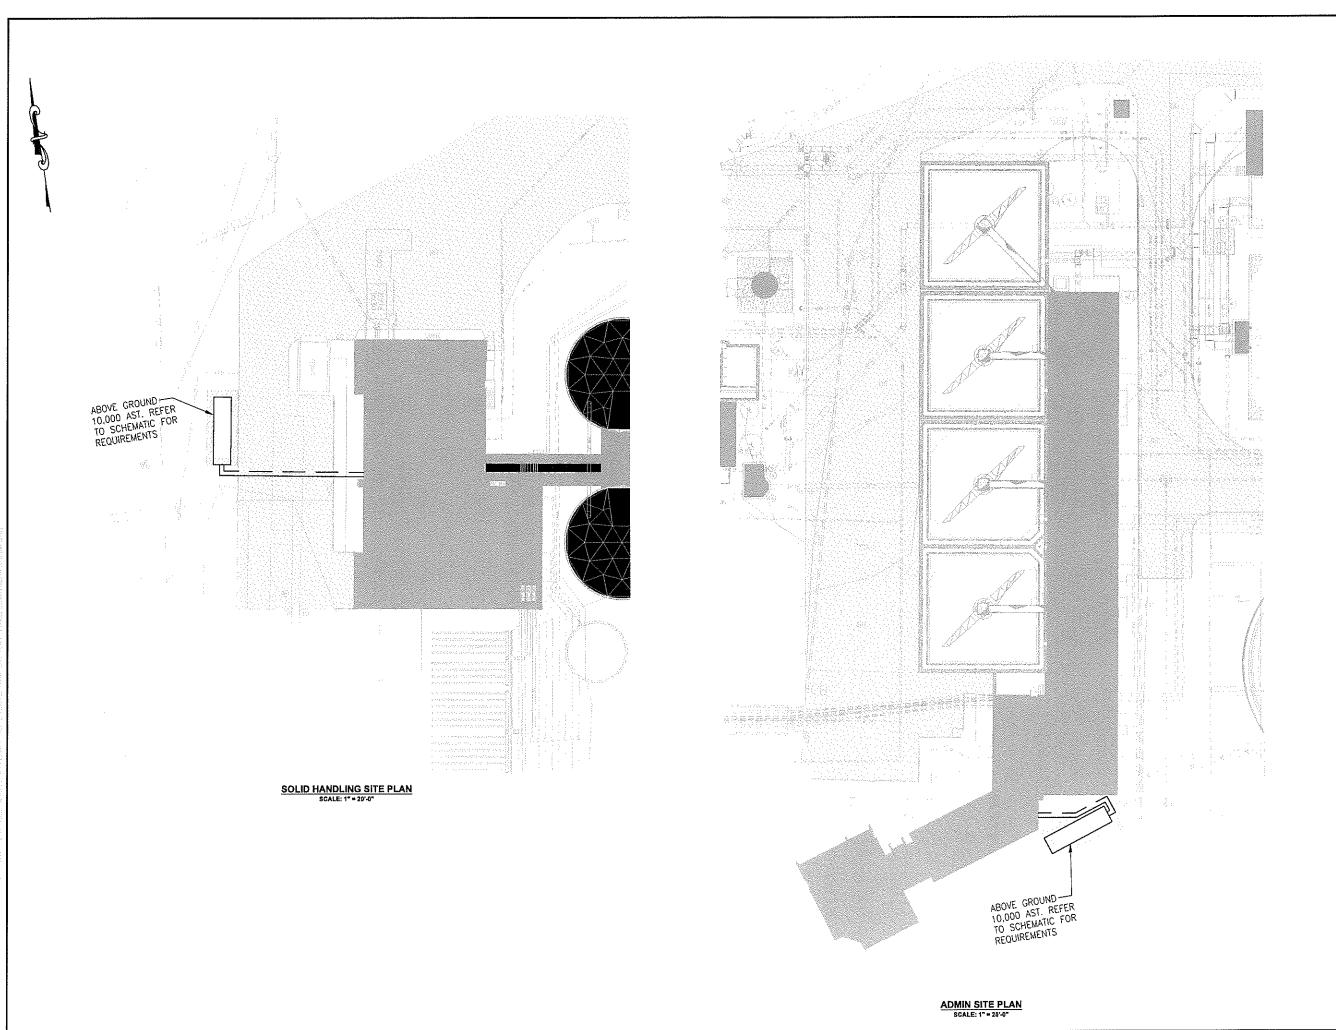

PREPARED BY

Www.BETA-Inc.com

REGISTERED PROFESSIONAL

SUBCONSULTANT



lechunical/Electrical Engineers 50 Grossman Drive, Suite 309 raintree, Massachusetts 02:184 17 328-9215

PROJECT

Taunton Wastewater Treatment Facility Improvements Phase 2

Taunton, MA


TITLE

HVAC Site Plan

l	ļ		
<u> </u>	<u>.</u>		
<u> </u>			
⊩			-
⊩			
NO.	RE	VISIONS	DATE
DR/	AWN BY:	RLB	
DES	SIGNED BY:	MC	
CHE	ECKED BY:	MC	
ISS	UE DATE:	10/16/2020	
BET	FA JOB NO.:	6050	
sc	ALE		
1			

Not for Construction

SHEET NO.

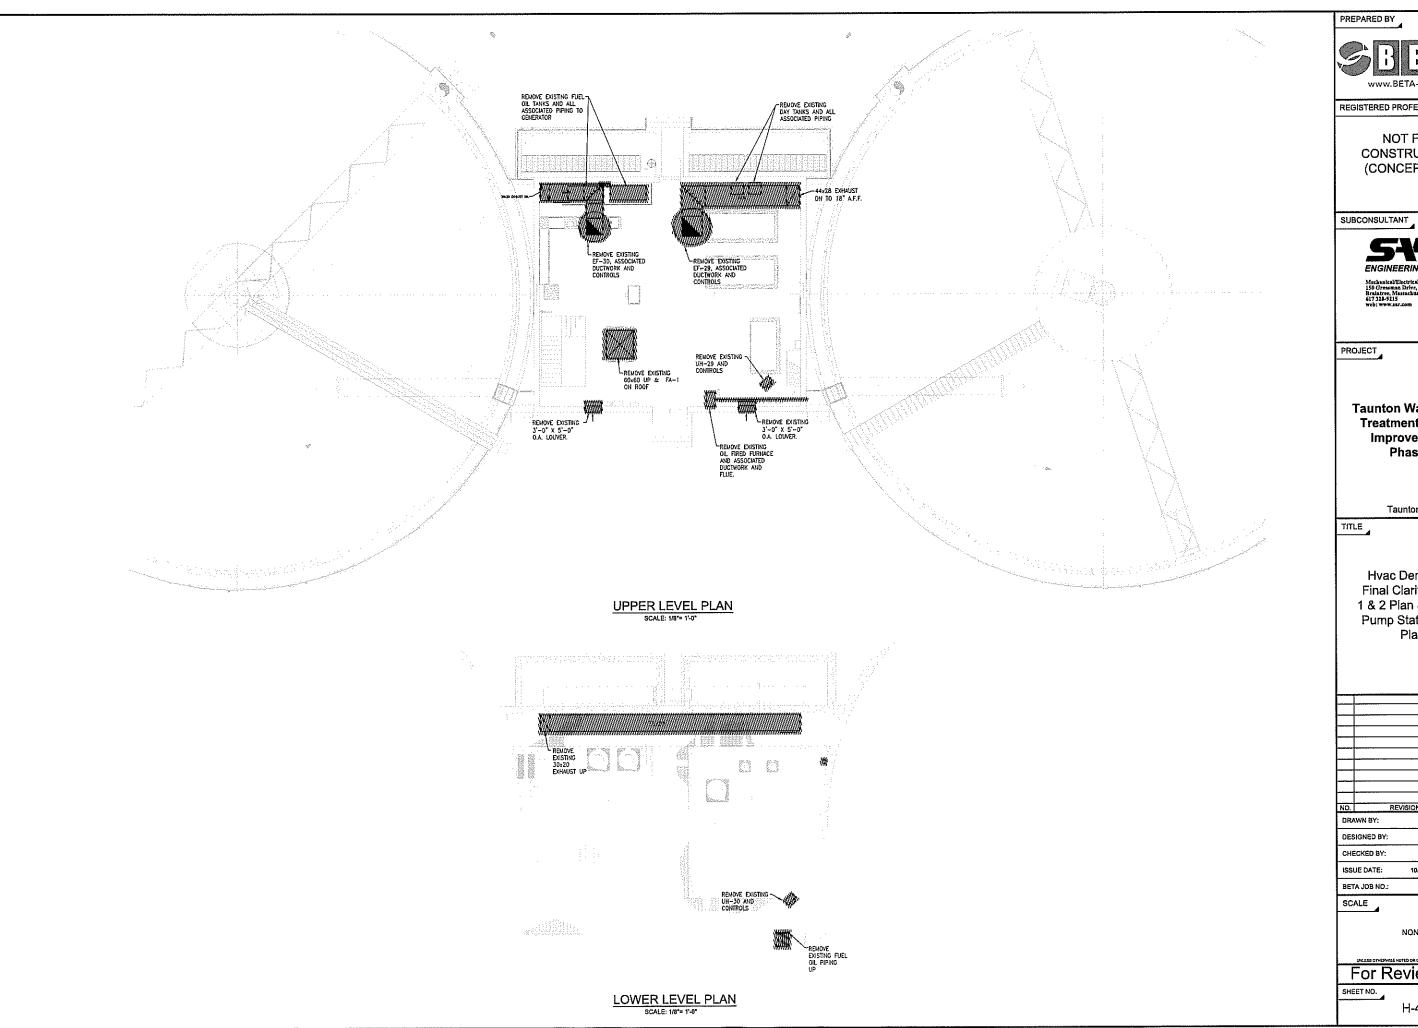



REGISTERED PROFESSIONAL

NOT FOR CONSTRUCTION (CONCEPTUAL)



Taunton Wastewater Treatment Facility Improvements Phase 2

Taunton, MA


Hvac Demolition Final Clarifiers No. 1 & 2 Plan & Sludge Pump Station No.1 Plan


_			
_			
_			
_			
			
_			
_			
<u>.</u>	RI	EVISIONS	DAT
v	WN BY:	RLB	
= 5	IGNED BY:	RH8	
18	ECKED BY:	RHB	
s	JE DATE:	10/16/2020	
Ę1	'A JOB NO.:	6050	

NONE

For Review Only

H-4.1

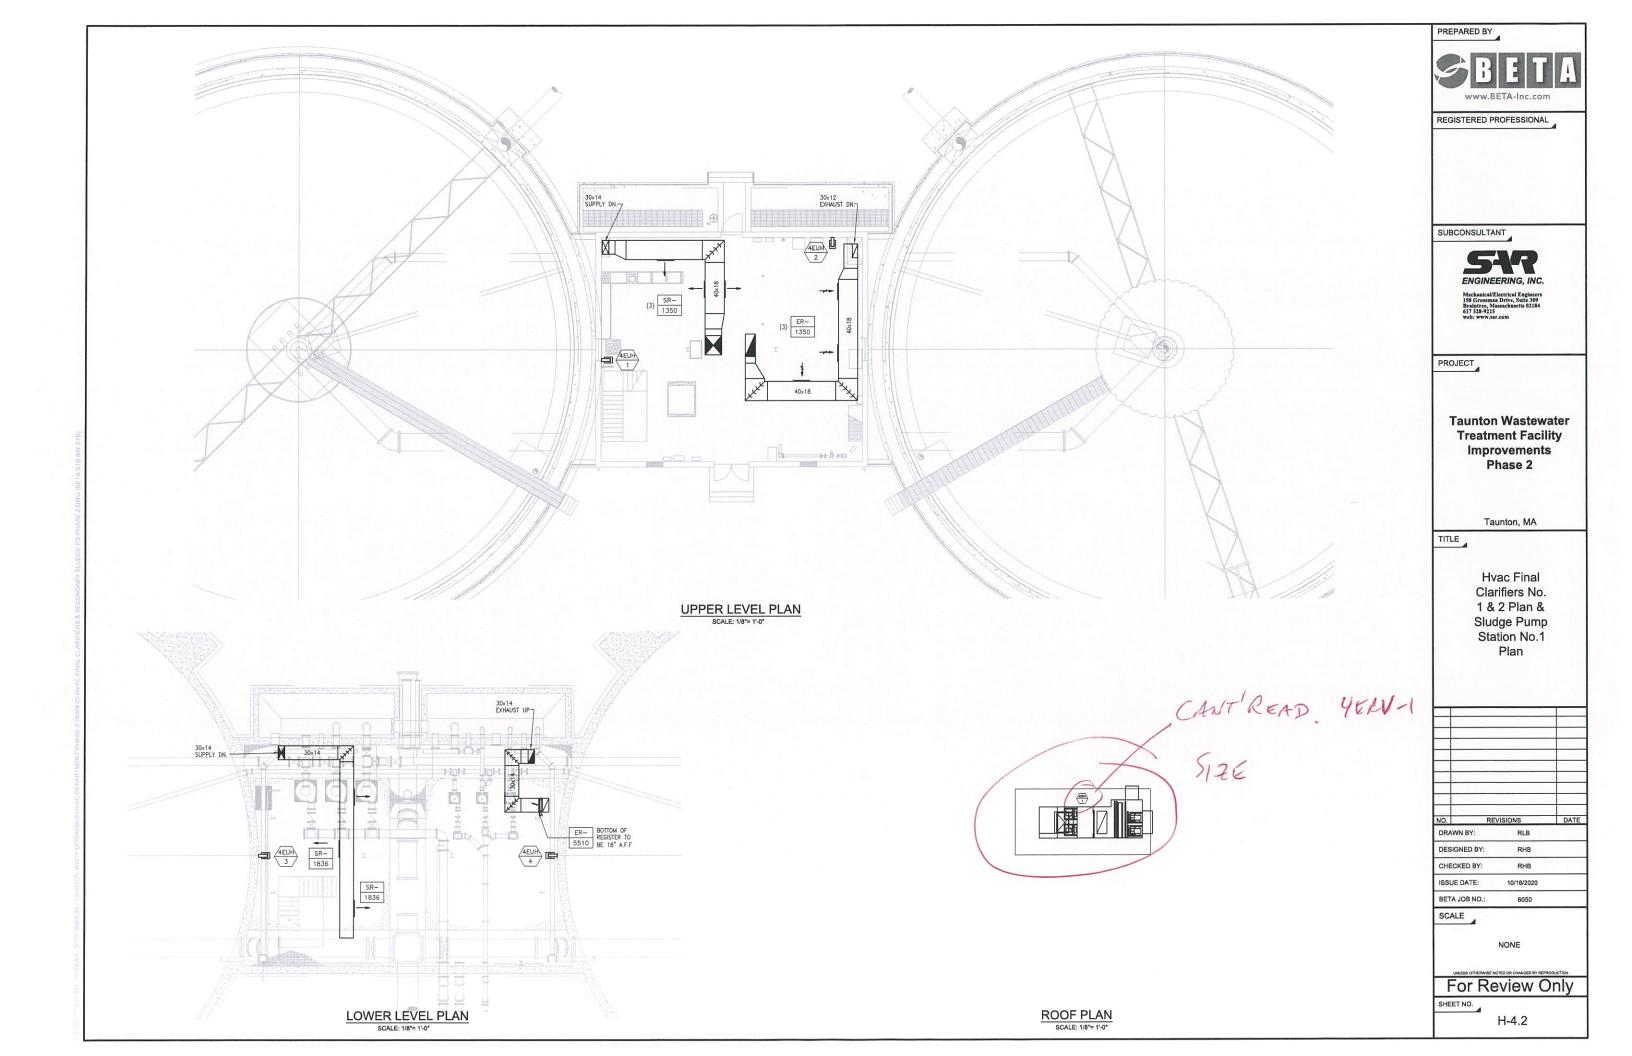

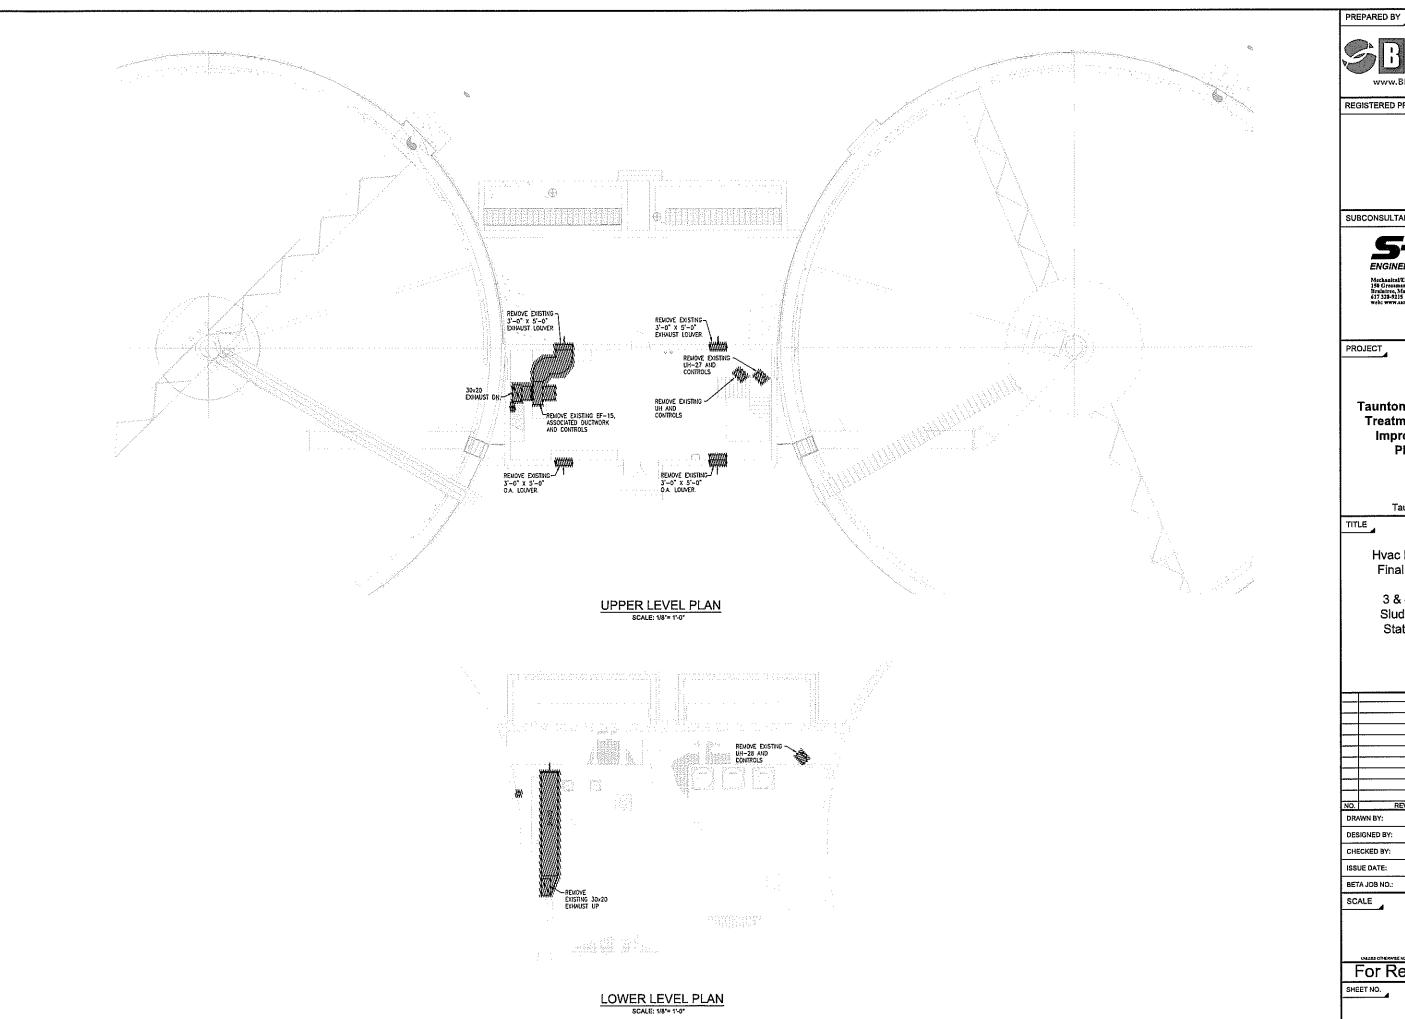



REGISTERED PROFESSIONAL

SUBCONSULTANT



Taunton Wastewater Treatment Facility Improvements Phase 2

Taunton, MA


Hvac Demolition Final Clarifiers No. 3 & 4 Plan & Sludge Pump Station No.2 Plan

		ļ
RE	VISIONS	DAT
AWN BY:	RLB	
SIGNED BY:	RHB	
ECKED BY:	RHB	
SUE DATE:	10/16/2020	
TA JOB NO.:	6050	
	· ·	

NONE

For Review Only

H-4.3

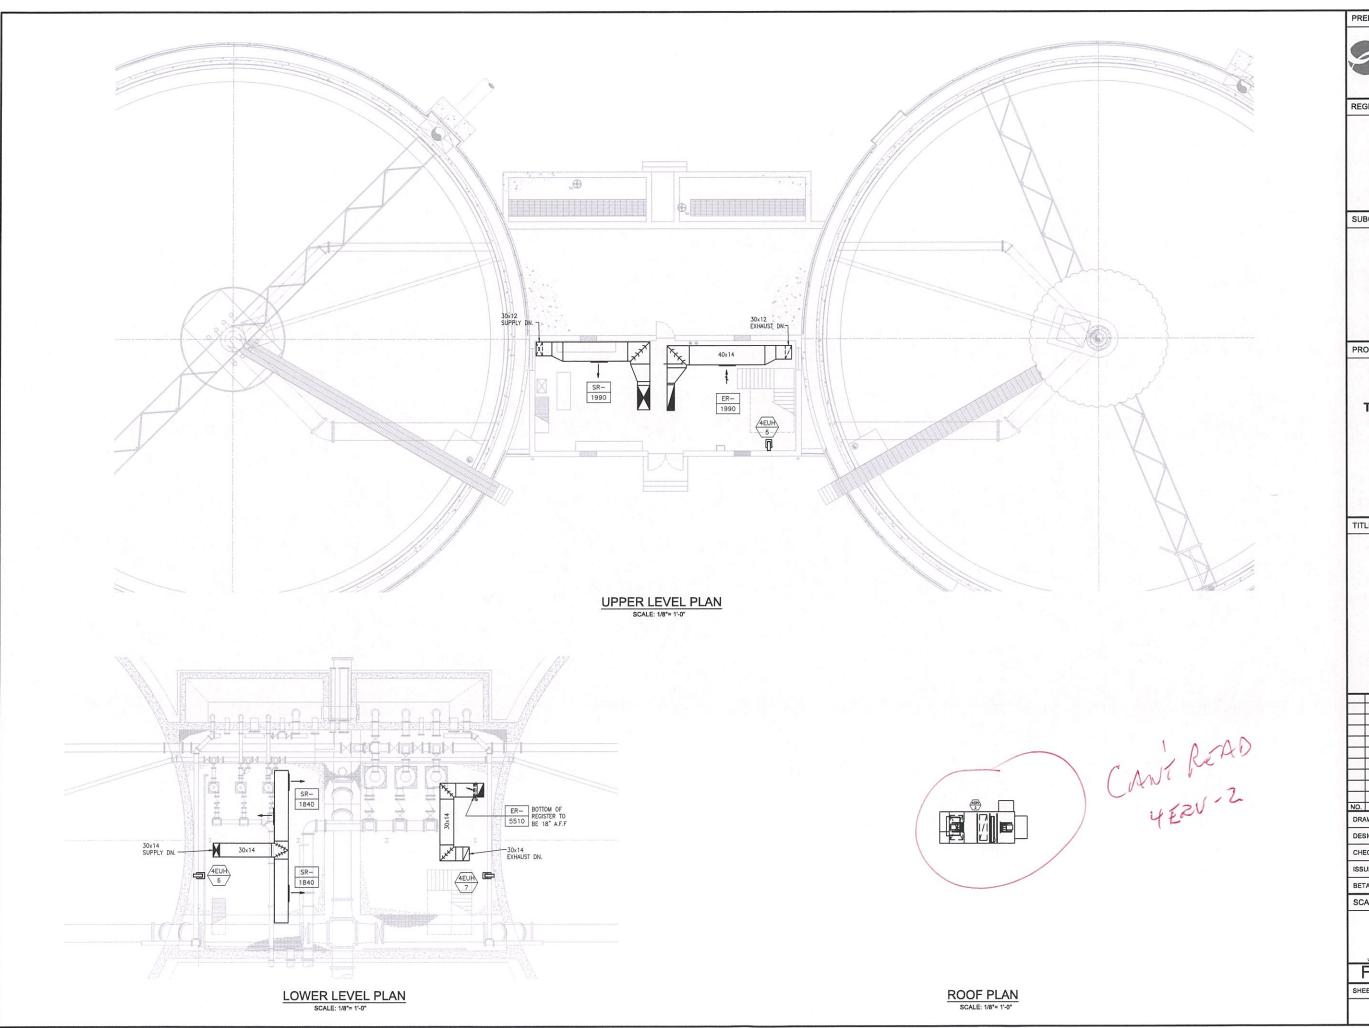

PREPARED BY

REGISTERED PROFESSIONAL

NOT FOR CONSTRUCTION (CONCEPTUAL)

SUBCONSULTANT



PROJECT

Taunton Wastewater Treatment Facility Improvements Phase 2

Taunton, MA

TITLE

Hvac Final Clarifiers No. 3 & 4 Plan & Sludge Pump Station No.2 Plan


		n Halla
		a PSG
DE	VISIONS	DATE
A STATE OF THE PARTY OF THE PAR	CONTROL CONTRO	DATE
WN BY:	RLB	
IGNED BY:	RHB	
CKED BY:	RHB	
JE DATE:	10/16/2020	
A JOB NO.:	6050	11
ALE		

NONE

For Review Only

SHEET NO.

H-4.4

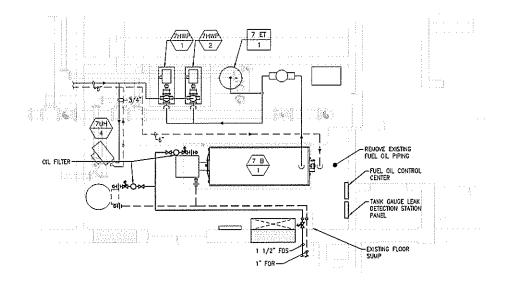

BOILER ROOM PART PLAN
SCALE: 1/4"= 1'-0"

PREPARED BY



REGISTERED PROFESSIONAL

NOT FOR CONSTRUCTION (CONCEPTUAL)

SUBCONSULTANT



Mechanica/Electrical Engineer 150 Grossman Drive, Suite 309 Braintree, Massachusetta 02184 617 328-9215 web: www.sar.com

PROJECT

Taunton Wastewater Treatment Facility Improvements Solids Handling

Taunton, MA

TITLE

Hvac Solid Handling Building Fuel Oil Plan

۵.	RE	EVISIONS	DATE
OR/	WN BY:	RLB	
DESIGNED BY:		RHB	
CHECKED BY:		RHB	
SSI	UE DATE:	10/16/2020	
ЭЕТ	A JOB NO.:	6050	


SCALE

NONE

For Review Only

SHEET NO.

H-7.1

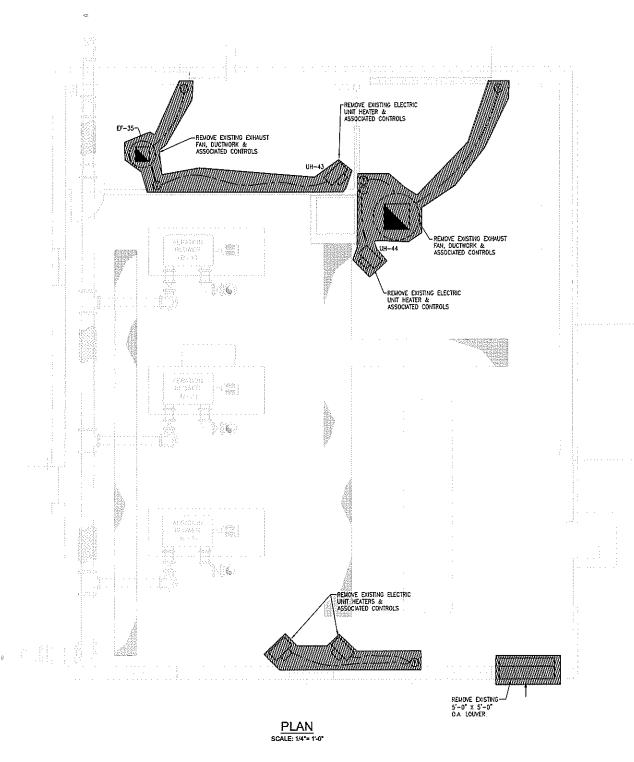

PREPARED BY



REGISTERED PROFESSIONAL

SUBCONSULTANT



Mechanical/Electrical Enginee 150 Grossman Drive, Suite 385 Braintree, Massachusetts 8218

PROJECT

Taunton Wastewater
Treatment Facility
Improvements
Phase 2

Taunton, MA

TITLE

Hvac Demolition Storage Building Plan

			\perp	
NO. REVISIONS		VISIONS	Ī)/
DRA	WN BY:	RLB		
DESIGNED BY:		RHB		
CHECKED BY:		RHB		
ISSUE DATE:		10/16/2020		
8E1	A JOB NO.:	6050		
SC.	ALE			


----4

AS SHOWN

For Review Only

SHEET NO.

H-9.2

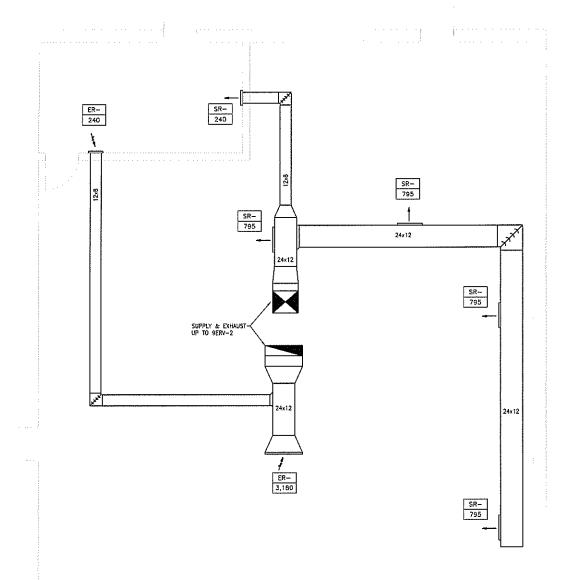

PLAN SCALE: 1/4"= 1'-0"

PREPARED BY



REGISTERED PROFESSIONAL

SUBCONSULTANT



PROJECT

Taunton Wastewater Treatment Facility Improvements Phase 2

Taunton, MA

TITLE

Hvac Storage Building Plan

				_
_				
			_	
			_	
NO.	RE	VISIONS	D/	Ñ
DRA	AWN BY:	RLB		
DES	SIGNED BY:	RHB		
CHE	ECKED BY:	RHB		
ISS	UE DATE:	10/16/2020		
BET	TA JOB NO.:	6050		_


SCALE

AS SHOWN

For Review Only

SHEET NO.

H-9.3

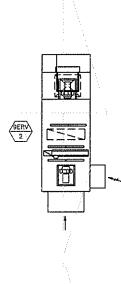

PLAN SCALE: 1/4"= 1'-0" PREPARED BY



REGISTERED PROFESSIONAL

SUBCONSULTANT



Meckanical/Electrical Engineers 158 Grossman Drive, Sulic 309 Braintree, Massachusetts 02184 617 328-9215 web: www.sar.com

PROJECT

Taunton Wastewater Treatment Facility Improvements Phase 2

Taunton, MA

TITLE

Hvac Storage Building Roof Plan

1				
<u> </u>				 <u>.</u>
L				
ŀ	VO.	R.	EVISIONS	DAT
	DR/	WN BY:	RLB	
	DES	IGNED BY:	RHB	
Γ	CHE	CKED BY:	RHB	
	ISS	UE DATE:	10/16/2020	
Γ	BET	A JOB NO.:	6050	

SCALE

AS SHOWN

For Review Only

SHEET NO.

H-9.4